

CLIENT



DATE

DESCRIPTION

DELTA

TAKE 5 CAR WASH

8108 OLD CARRIAGE CT. N.
SHAKOPEE, MN

ARCHITECT



ENGINEER

STAMPS

THIS DRAWING FOR PERMITTING AND BID PURPOSES ONLY. NOT FOR CONSTRUCTION

THESE PLANS ARE INSTRUMENTS OF PROFESSIONAL SERVICE AND ARE PROTECTED BY COMMON LAW, STATUTORY AND OTHER RESERVED RIGHTS INCLUDING COPYRIGHT. THEY MAY NOT BE REPRODUCED OR USED FOR ANY PURPOSE WITHOUT THE WRITTEN CONSENT OF THE ARCHITECT

SHEET TITLE

FLOOR PLAN

PROJECT NUMBER
22-0017


DATE: 08.25.2022
SCALE: AS NOTED
DRAWN: XX
CHECKED: XX
SHEET NO.



1

ARCHITECTURAL FLOOR PLAN

3/16" = 1'-0"

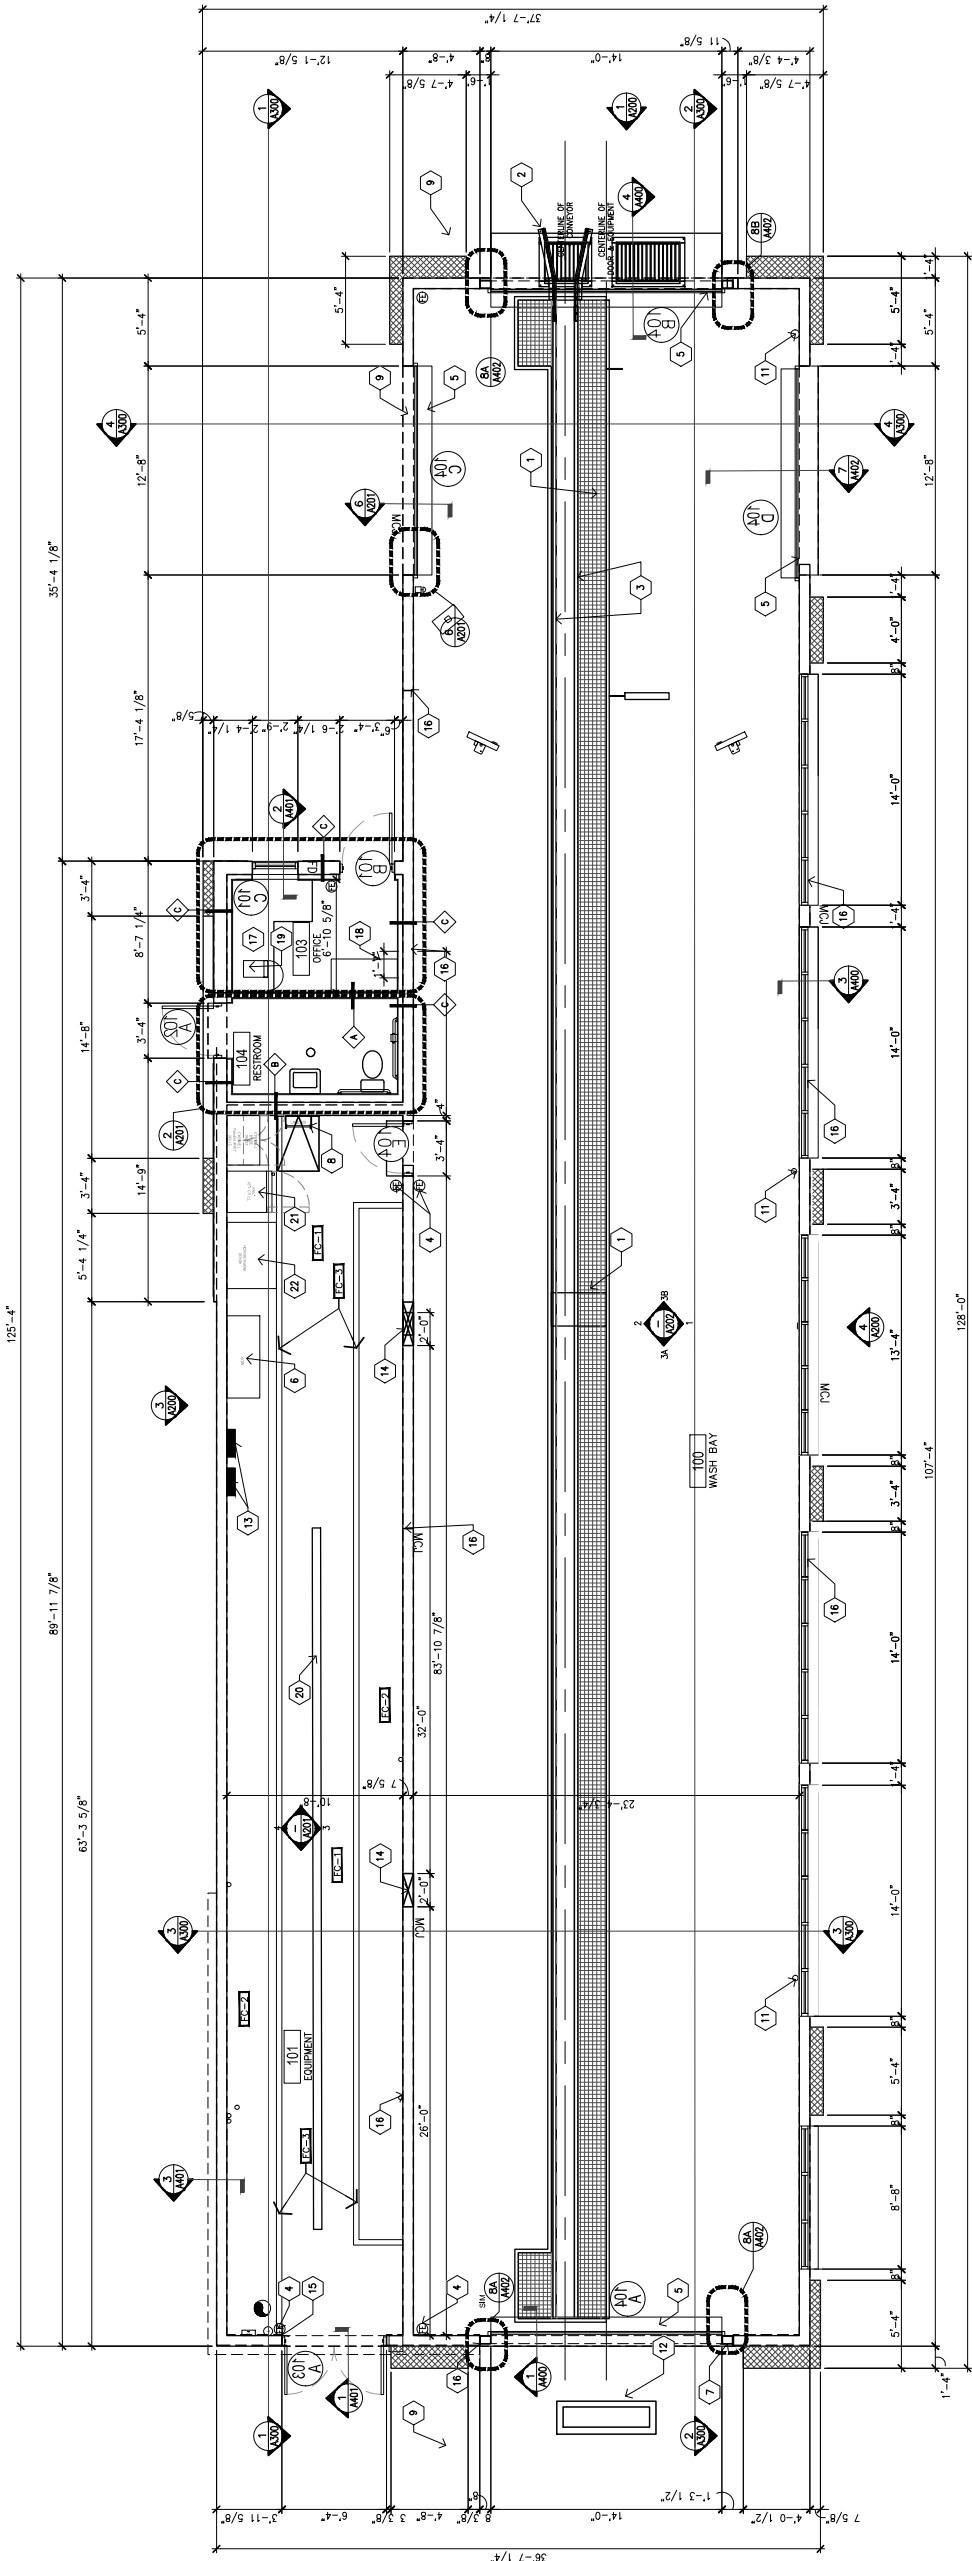

WALL PARTITION LEGEND

- 2x4 15'-0" STUD WALL TO 8' ABOVE CEILING, WEIRAT INSUL. AND WP-1 VINYL PANEL FINISH, FASTEN TOP PLATE TO JOISTS PER STRUCTURAL FASTENING SCHEDULE
- CMU WALLS TO RECEIVE 2 COATS OF BLOCK FILL PRIMER, EXTERIOR SEALANT, CONT. AT JTS BETWEEN CMU. INSTALL WP-1 OVER 2x4 STUD WALL. CI SIZING PER ENERGY REQUIREMENTS.
- CMU WALLS TO RECEIVE 2 COATS OF BLOCK FILL PRIMER, EXTERIOR SEALANT, CONT. AT JTS BETWEEN CMU. INSTALL WP-1 OVER 2x4 STUD WALL. CI SIZING PER ENERGY REQUIREMENTS.

OWNER FURNISHED PRODUCTS AND NOTES

- SEWER CABINET AND SAE FURNISHED AND INSTALLED BY OWNER'S CONTRACTOR. ELECTRICAL CONTRACTOR SHALL INSTALL PORET AND COMMUNICATION CORDIT PER ELECTRICAL.
 - CONVEYOR GRATING FURNISHED AND INSTALLED BY OWNER'S CONTRACTOR.
- ### GENERAL NOTES
- DIMENSIONS ARE MEASURED FROM FACE OF CMU.
 - REFER TO WALL LEGEND FOR PARTITION TYPES.
 - THE APPROVED AND STAMPED CONSTRUCTION DOCUMENTS SHALL REMAIN ON SITE AT ALL TIMES.
 - REFER TO SHEET A500 FOR DOOR AND WINDOW SCHEDULE.
 - IT IS THE INTENT THAT THIS PROJECT IS IN COMPLIANCE WITH ALL FEDERAL, STATE, AND LOCAL CODES AND REGULATIONS. THE GENERAL CONTRACTOR SHALL BE RESPONSIBLE FOR VERIFYING THE ACCURACY OF ALL DIMENSIONS AND LOCATIONS. ANY DISCREPANCIES BETWEEN THE ARCHITECT'S DRAWINGS AND THE FIELD CONDITIONS SHALL BE IMMEDIATELY REPORTED TO THE ARCHITECT. ANY WORK IN QUESTION SHALL NOT COMMENCE UNTIL WRITTEN CLARIFICATION IS ISSUED BY THE ARCHITECT.
 - REFER TO A102 FOR EQUIPMENT PLAN.
 - UNLESS NOTED OTHERWISE, MASONRY CONTROL JOINTS SHALL BE LOCATED SUCH THAT NO STRAIGHT RUN OF MASONRY WALL EXCEEDS 24'-0". REFER TO GENERAL STRUCTURAL NOTES ON S100.
 - REFER TO A501 FOR FINISH SCHEDULE.
 - EXPOSED ROOF DRAIN LEADERS/PIPING TO BE PAINTED TO MATCH VINYL WALL COVERINGS.

FLOOR PLAN KEYNOTES

- CONVEYOR TRENCH
- CORRELATOR
- CONVEYOR AND GRATING.
- FIRE EXTINGUISHER, REFER TO G001 (PER LOCAL FIRE MARSHALL AND JURISDICTION)
- OVERHEAD COILING DOOR.
- MAIN DISTRIBUTION PANEL. REFER TO ELECTRICAL
- ILLUMINATED SIGNAGE. REFER TO SIGNAGE PACKAGE (ABOVE).
- FIXED LADDER, MANUFACTURER, TRIP-ARC OR SIMILAR.
- CANOPY ABOVE BY SIGNAGE VENDOR
- TOWER, REFER TO STRUCTURAL; ELEVATIONS FOR COLOR/FINISH
- ROOF DRAIN LEADER, REFER TO PLUMBING
- 2' X 6' ANTI COLLISION INDUCTION LOOP FURNISHED BY OWNER, INSTALLED BY G.C. G.C. TO COORDINATE DELIVERY WITH OWNER AS TO NOT CAUSE ANY DELAYS IN THE CONSTRUCTION SCHEDULE
- ELECTRICAL PANEL. REFER TO ELECTRICAL DRAWINGS
- 24" X 8" BLOCK OUT IN CMU WALL FOR CABLE TRAY PASS THROUGH. 10'-8" ABOVE FINISHED FLOOR TO BOTTOM OF OPENING. SEE 1/A201
- ALIGN EPOXY FLOOR COATING COLOR TRANSITION WITH CORNER OF CMU JAMB AND THRESHOLD
- PREFORMED MASONRY CONTROL JOINT (MCJ), REFER TO DETAIL 8/A404 & STRUCTURAL DRAWINGS
- 2'-6" WIDE COUNTERTOP, SEE 8/A403.
- 2'X4" IT CAGE.
- SAFE BY OWNER, SEE 8/A403.
- 6" TRENCH DRAIN; REFER TO PLUMBING
- REFRIGERATOR (BY OWNER); REFER TO ELECTRICAL FOR CONVENIENCE OUTLET
- WORKTABLE (BY OWNER); REFER TO ELECTRICAL FOR CONVENIENCE OUTLET