

KEYNOTES

NUMBER	DESCRIPTION
CA-01	MULTI-PRODUCT DISPENSER. SEE FUEL DRAWINGS
CA-02	CONCRETE PAVING. SEE CIVIL SHEET & STRUCT. DRAWINGS
CA-03	36" HIGH, 6" BOLLARD, QTY. 2 AT EACH END OF DISPENSER. REFER TO FUEL DRAWINGS
CA-04	STEEL CANOPY COLUMN. SEE FUEL CANOPY STRUCTURAL DRAWINGS
CA-05	LINE OF CANOPY ABOVE



Bergmann Architects, Engineers, Planners, P.C.
10000 Highway 100, Suite 200, Minneapolis, MN 55412

COPYRIGHT NOTICE
This drawing is the property of the above referenced Professional and is not to be used for any purpose other than the specific project and site named herein, and cannot be reproduced in any manner without the express written permission from the professional.

PROFESSIONAL SEAL

PROFESSIONAL CERTIFICATION

I hereby certify that this plan, specification or report was prepared by me or under my direct supervision and that I am a duly Licensed Architect under the laws of the state of Minnesota.

Signature: _____

Typed/Printed Name: _____

Date: _____

License Number: _____

PERMIT SET 04/12/2023

REVISIONS	ISSUE	DATE

PROJECT MANAGER
A. SIGNOR
QUALITY CONTROL
A. SIGNOR
DRAWN BY
J. MASON

PROJECT NAME

HOLIDAY
STATIONSTORES LLC

SHAKOPEE, MN


SWC WINDERMERE WAY &
MARYSTOWN RD



HOLIDAY STATIONSTORES, INC.
PROJECT NUMBER:
016372.00

FUEL CANOPY
PLAN (DS08)

CA-1

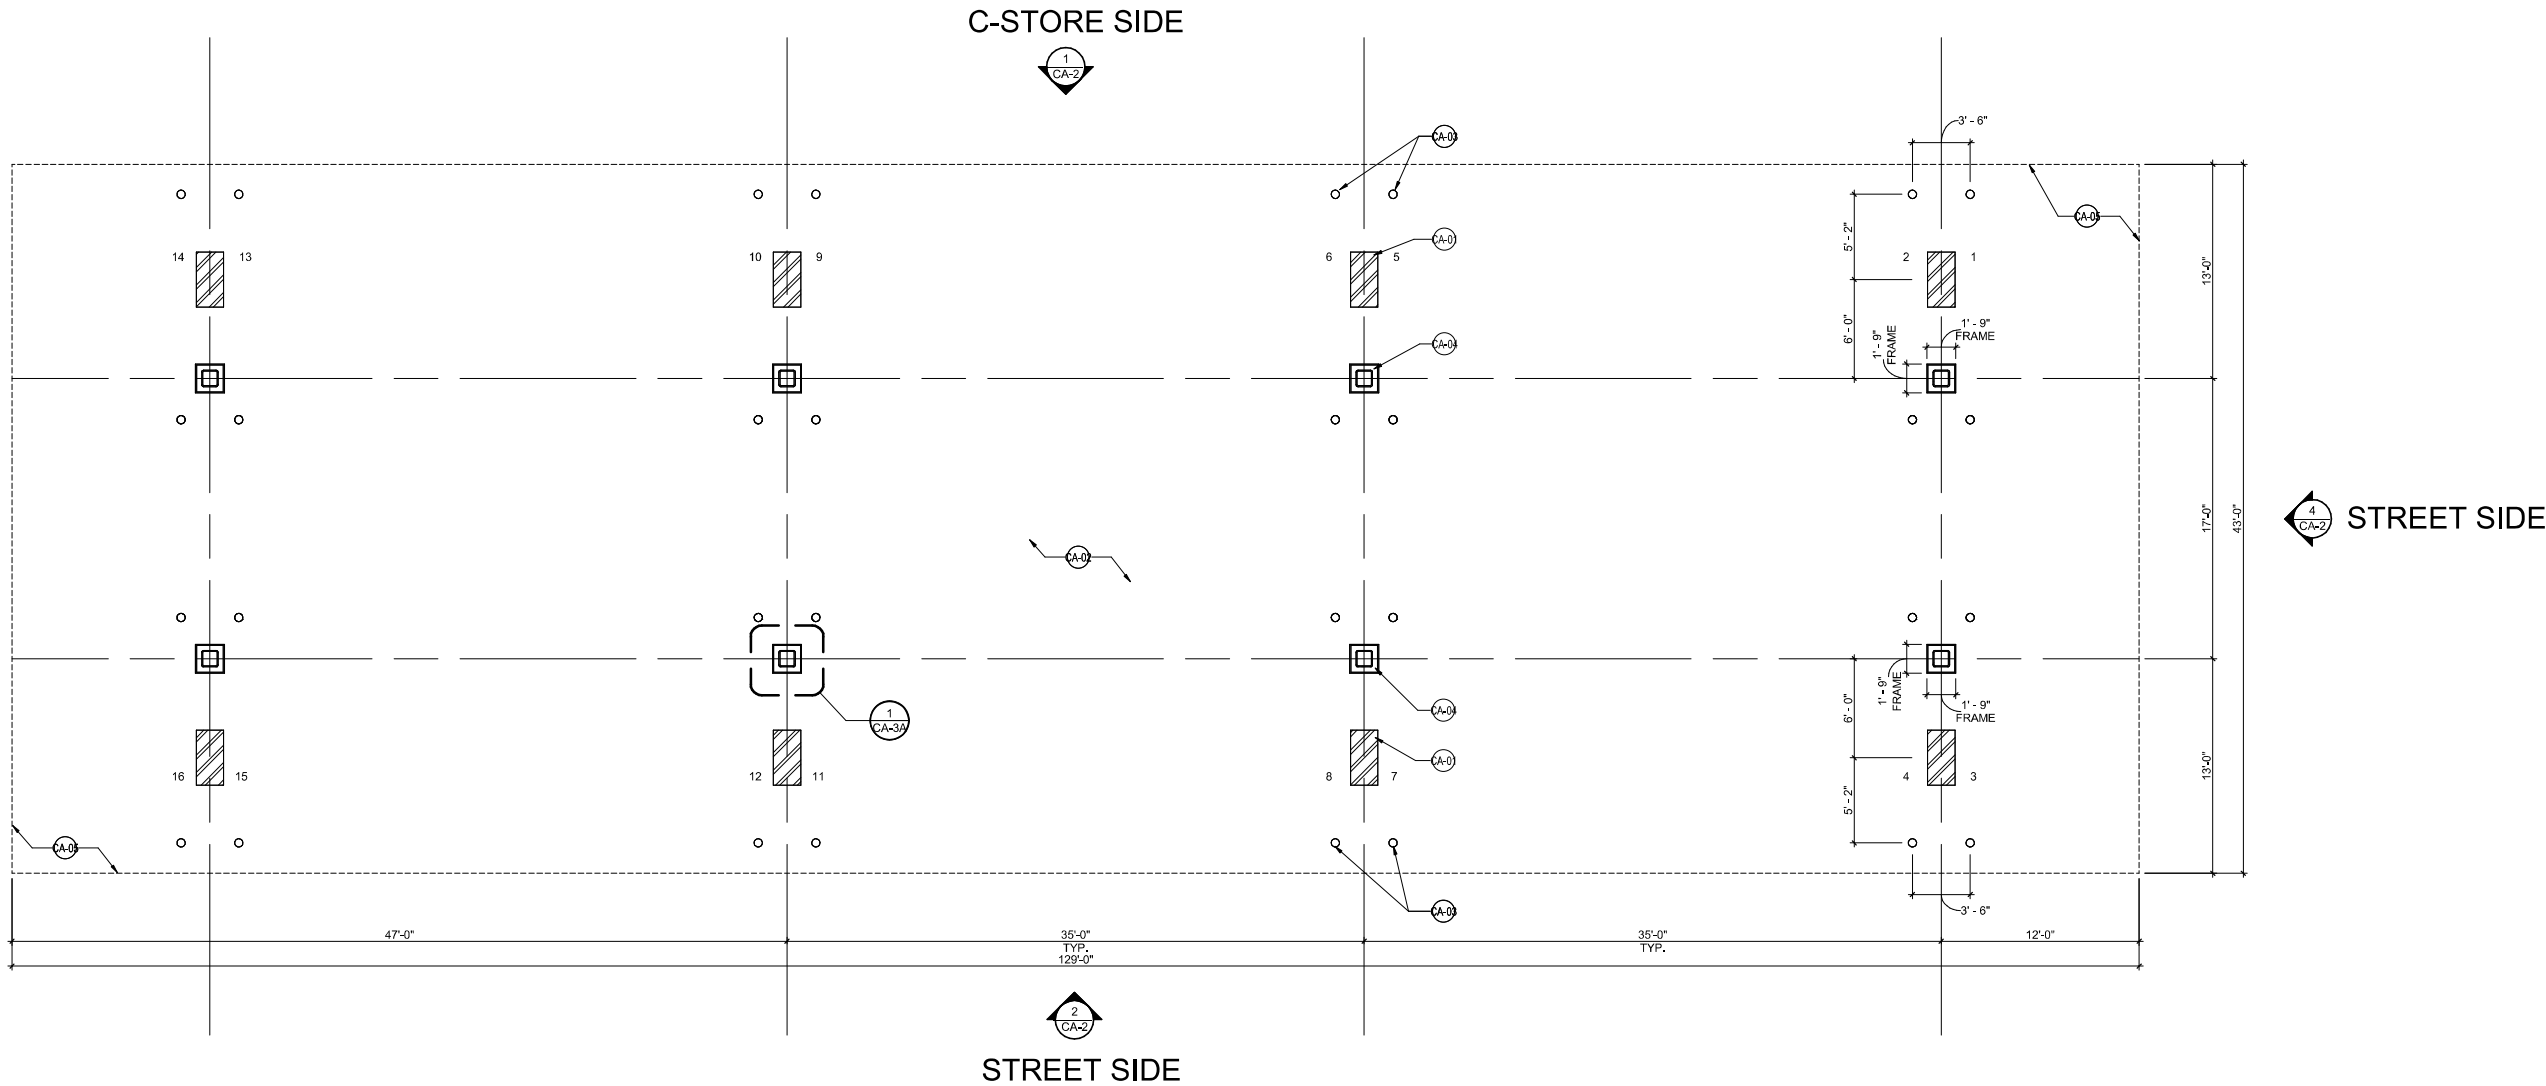


FUEL CANOPY PLAN

1


3/16" = 1'-0"



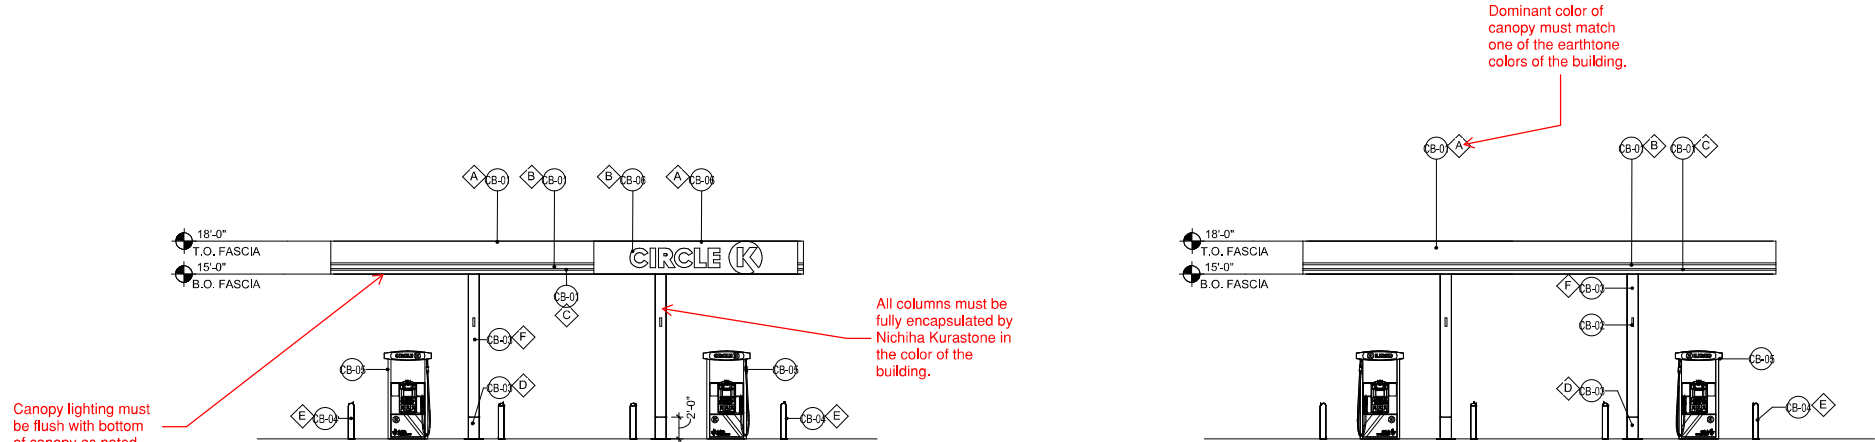


SIDE ELEVATION (SOUTH) | 4
1/8" = 1'-0"

SIDE ELEVATION (NORTH) | 3
1/8" = 1'-0"

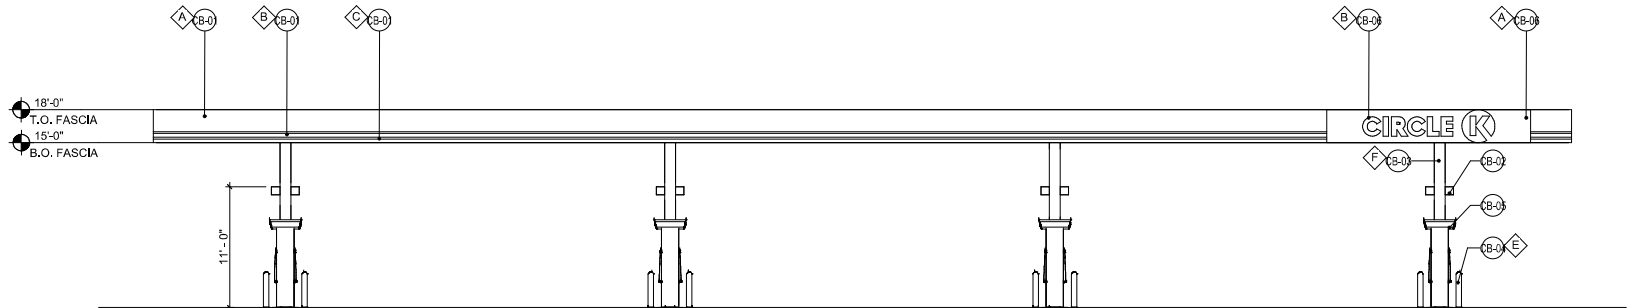

FRONT ELEVATION (EAST) | 2
1/8" = 1'-0"

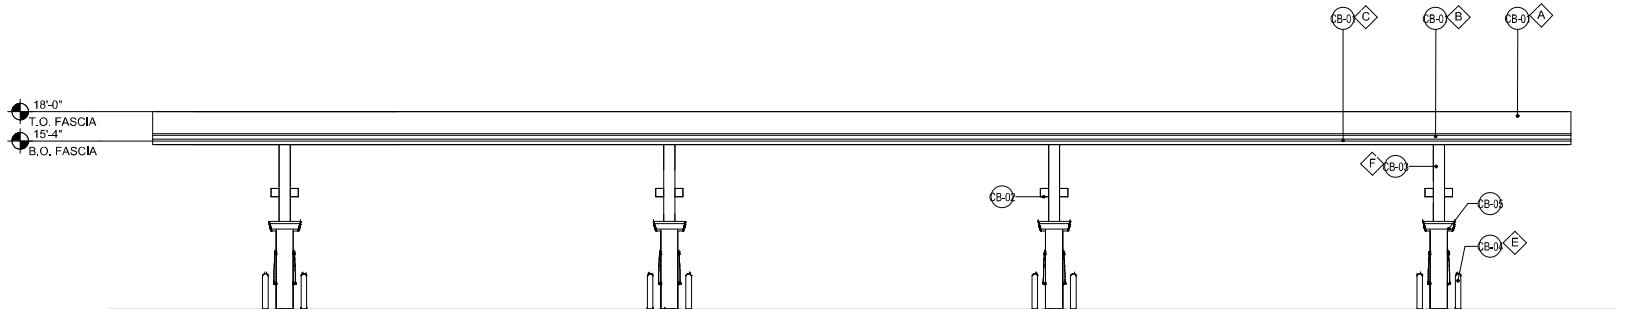

REAR ELEVATION (WEST) | 1
1/8" = 1'-0"

KEY NOTES

NUMBER	DESCRIPTION
CB-01	ACM PANEL *TEX-COTE
CB-02	COLUMN FLAGS BY SIGNAGE VENDOR
CB-03	STEEL COLUMN WITH PAINT FINISH
CB-04	6" BOLLARD, 36" HIGH
CB-05	FUEL PUMP
CB-06	INTERNALLY ILLUMINATED SIGN UNDER SEPARATE PERMIT

FINISH SCHEDULE

A	CIRCLE K RED #PMS 485
B	CIRCLE K WHITE
C	CIRCLE K ORANGE #PMS 144
D	SHERWIN WILLIAMS - SW6236 - GRAYS HARBOR
E	PVC BOLLARD SLEEVE - DARK GRAY
F	RAL9016 SHELL WARM WHITE

- NOTES:
- COLORS SHOWN ON THESE ELEVATIONS ARE FOR ILLUSTRATION PURPOSES ONLY. FOR ACTUAL COLORS, REFER TO MANUFACTURER'S SAMPLES.
 - THE FASCIA PANELS ARE PRE-FINISHED BY SIGNAGE VENDOR
 - ALL SIGNS REQUIRE A SEPARATE SUBMITTAL
 - ALL LIGHTING ON CANOPY TO BE FLUSH MOUNTED WITH FASCIA

B BERGMANN
ARCHITECTS ENGINEERS PLANNERS
Bergmann Architects, Inc. is a full-service architectural, engineering, and planning firm. This drawing is the property of the above referenced Professional and is not to be used for any purpose other than the specific project and site named herein, and cannot be reproduced in any manner without the express written permission from the professional.

PROFESSIONAL SEAL

PROFESSIONAL CERTIFICATION

I hereby certify that this plan, specification or report was prepared by me or under my direct supervision and that I am a duly Licensed Architect under the laws of the state of Minnesota.

Signature: _____

Typed/Printed Name: _____

Date: _____

License Number: _____

PERMIT SET 04/12/2023

REVISIONS	ISSUE	DATE

PROJECT MANAGER
A. SIGNOR
QUALITY CONTROL
A. SIGNOR
DRAWN BY
J. MASON

PROJECT NAME

HOLIDAY
STATIONSTORES LLC

SHAKOPEE, MN


SWC WINDERMERE WAY &
MARYSTOWN RD




HOLIDAY STATIONSTORES, INC.
PROJECT NUMBER:
016372.00

FUEL CANOPY
EXTERIOR
ELEVATIONS

CA-2

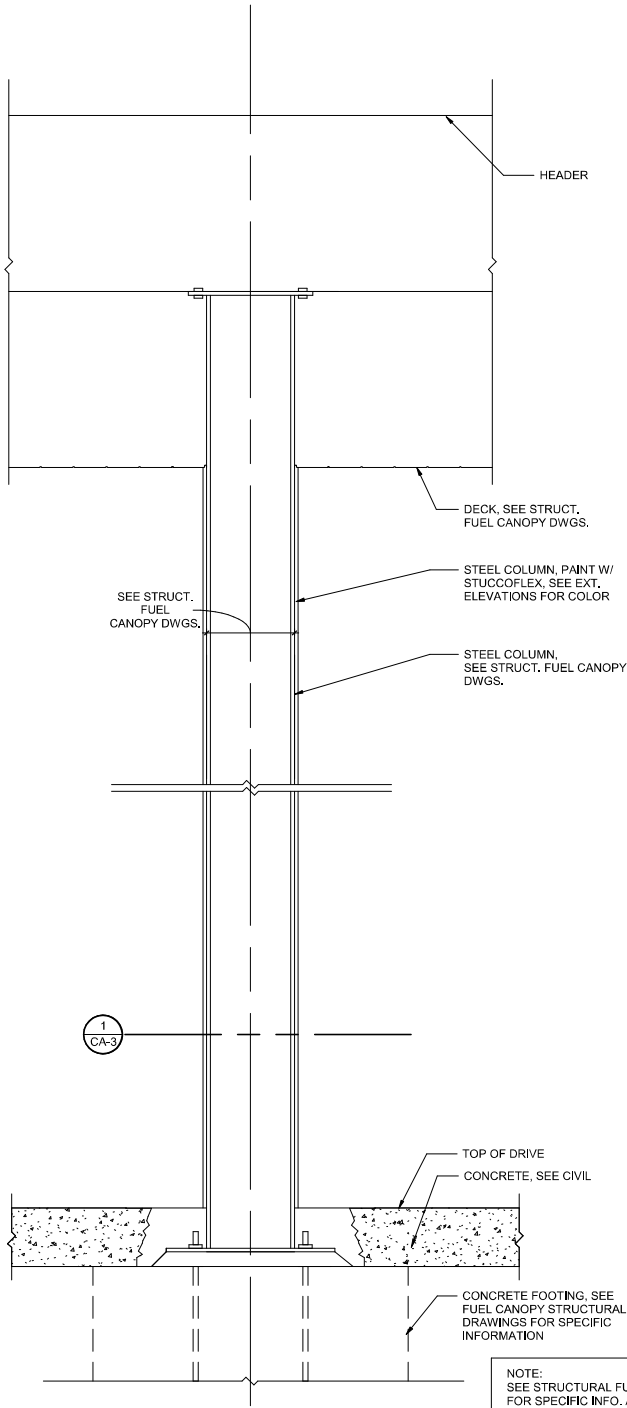

COLUMN SECTION @FUEL CANOPY -TYP. | 2
1" = 1'-0"

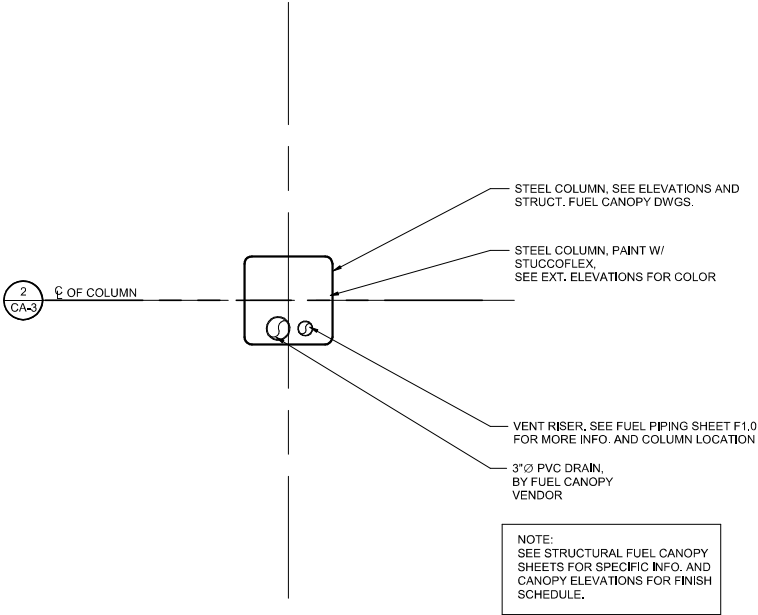

FUEL CANOPY COLUMN PLAN- TYP. | 1
1" = 1'-0"

CLASS C COLUMN FINISH

GENERAL NOTES

1. SEE STRUCTURAL FUEL CANOPY DWGS FOR MORE INFORMATION.
2. SEE EXTERIOR CANOPY ELEVATIONS FOR FINISH.

B

BERGMANN

ARCHITECTS ENGINEERS PLANNERS

Bergmann Architects, Engineers, Planners, P.C.

10000 Hennepin Avenue, Suite 100
Minneapolis, Minnesota 55412-1000

COPYRIGHT NOTICE

This drawings is the property of the above referenced Professional and is not to be used for any purpose other than the specific project and site named herein, and cannot be reproduced in any manner without the express written permission from the professional

PROFESSIONAL SEAL

PROFESSIONAL CERTIFICATION

I hereby certify that this plan, specification or report was prepared by me or under my direct supervision and that I am a duly Licensed Architect under the laws of the state of Minnesota.

Signature: _____

Typed/Printed Name: _____

Date: _____

License Number: _____

PERMIT SET 04/12/2023

REVISIONS	
ISSUE	DATE

PROJECT MANAGER
A. SIGNOR
QUALITY CONTROL
A. SIGNOR
DRAWN BY
J. MASON

PROJECT NAME

HOLIDAY
STATIONSTORES LLC

SHAKOPEE, MN

SWC WINDERMERE WAY &
MARYSTOWN RD



HOLIDAY STATIONSTORES, INC.
PROJECT NUMBER:
016372.00

FUEL CANOPY -
COLUMN
DETAILS

CA-3