


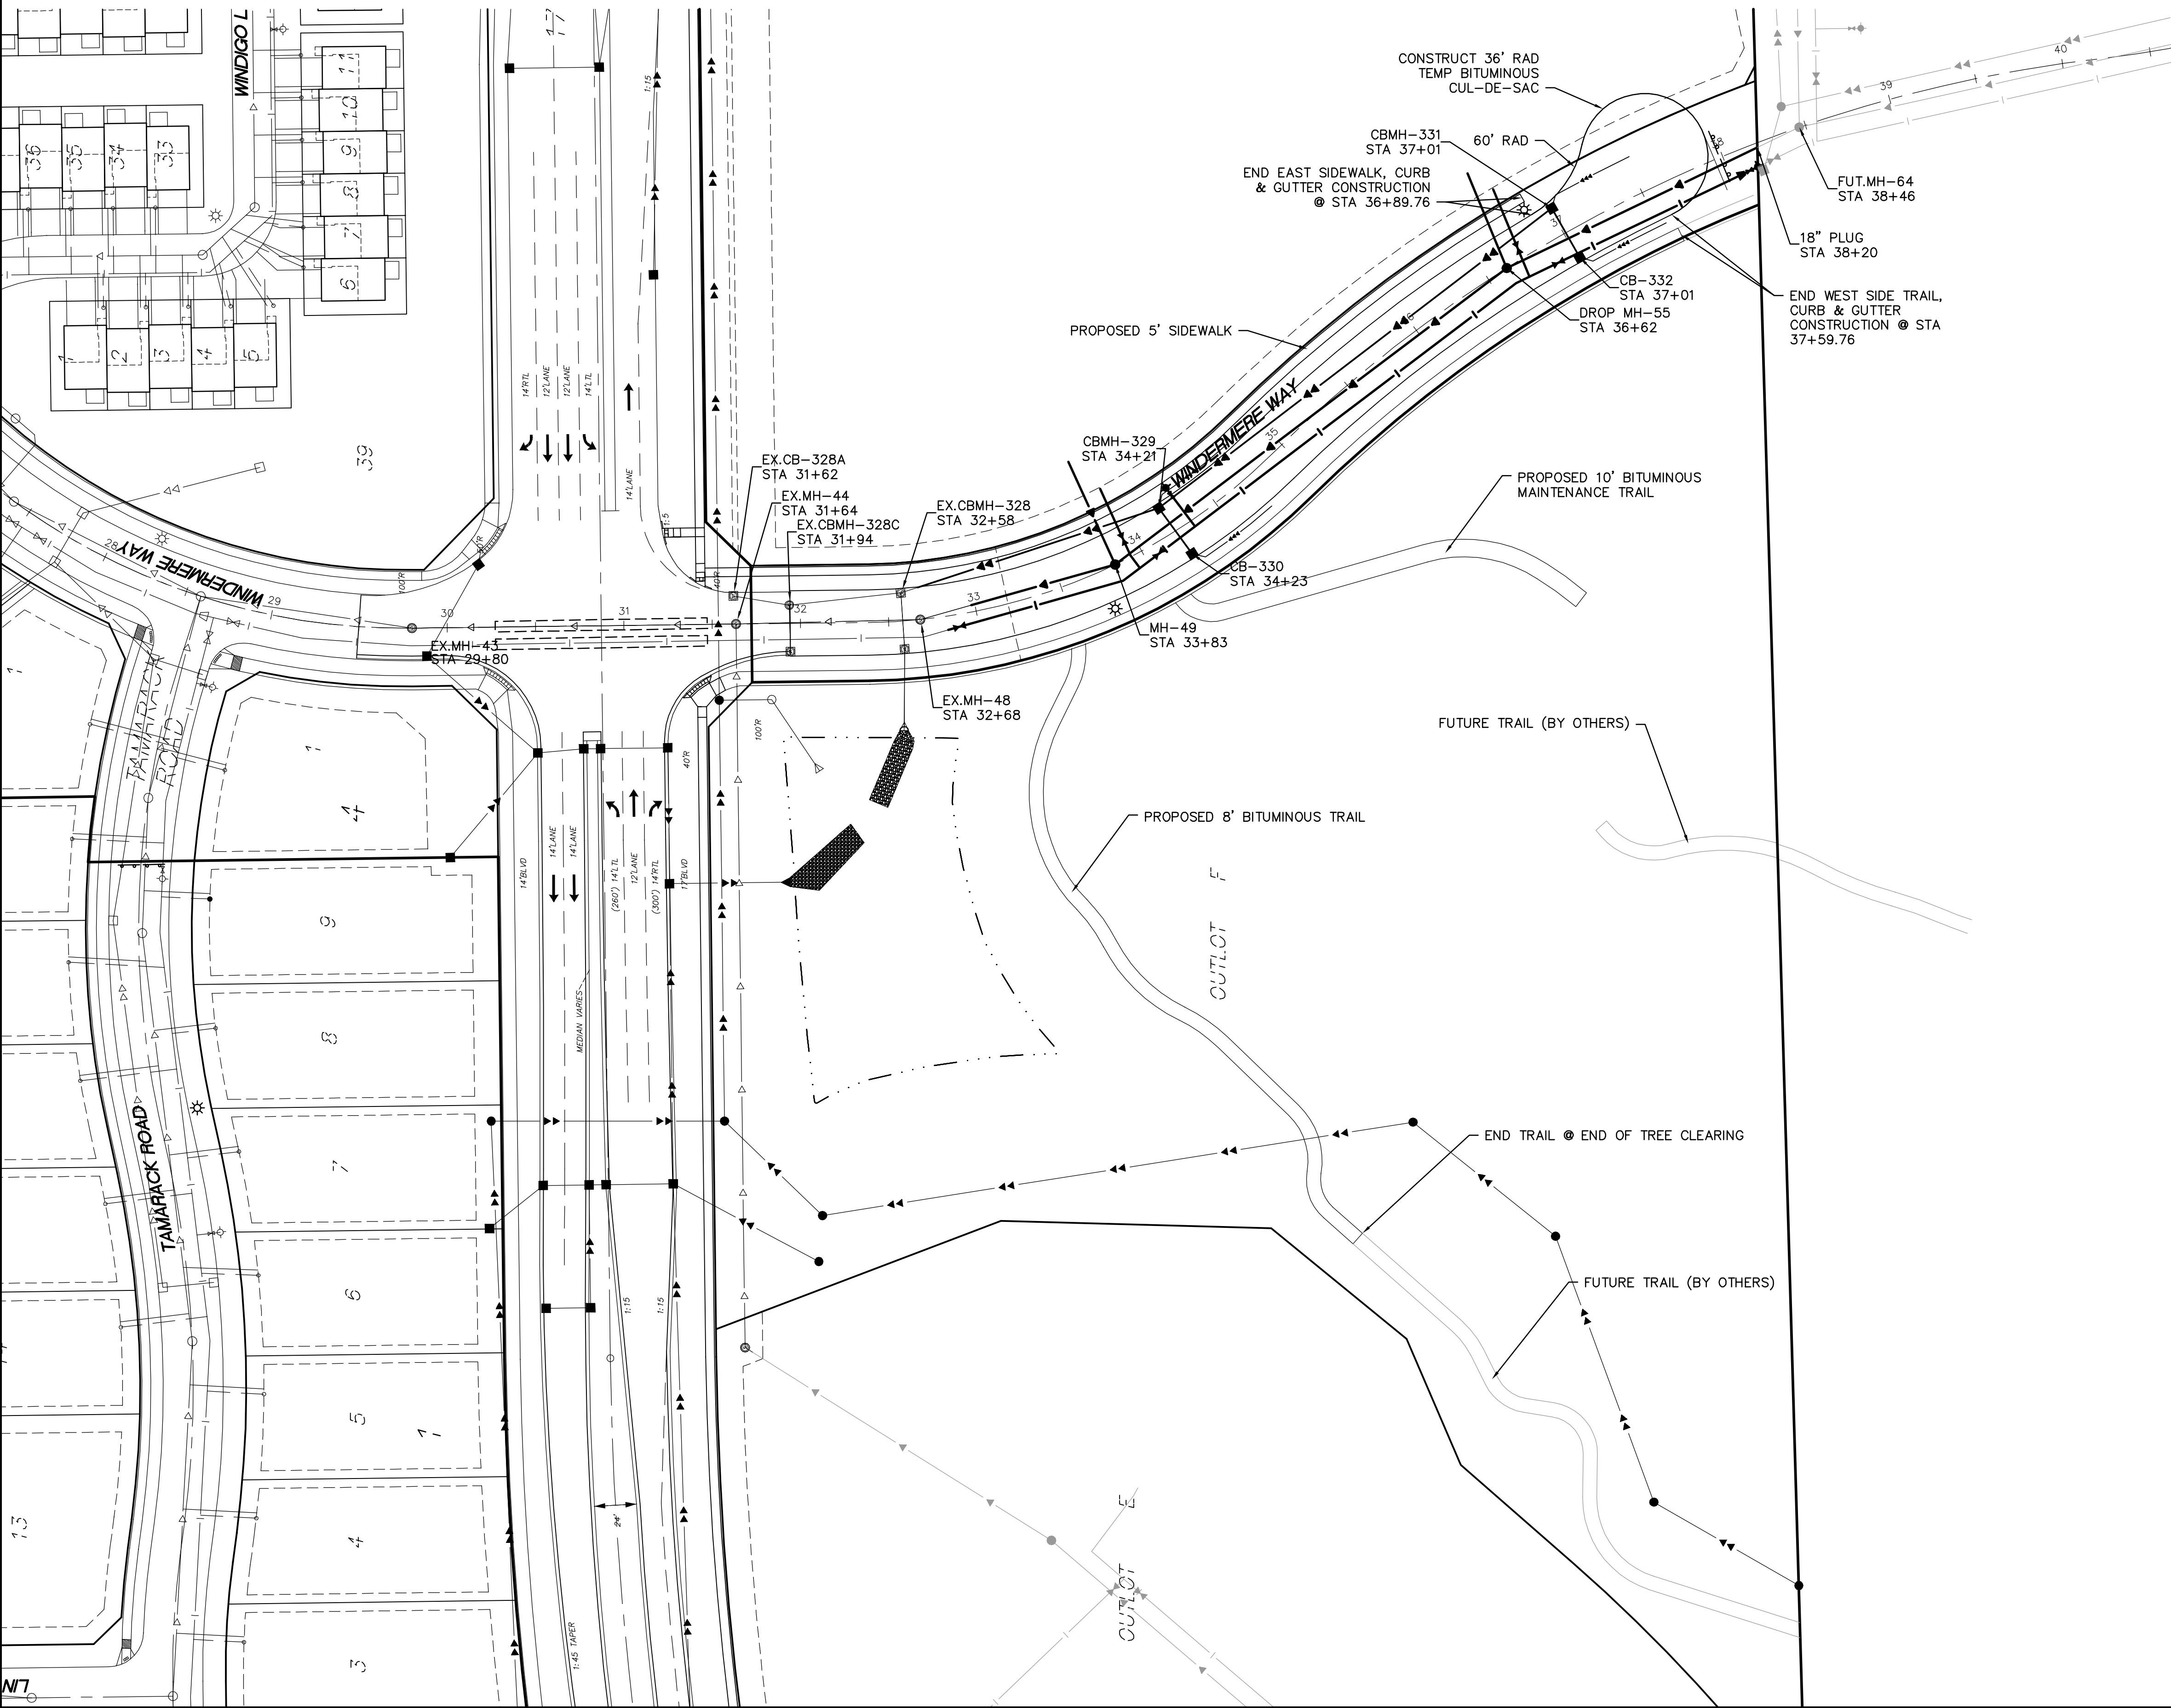


UTILITY LINES

EXISTING	
Sanitary Sewer	
Water	
Hyd. w\Valve	
Storm Sewer	
PROPOSED	
Sanitary Sewer	
Water	
Hyd. w\Valve	
Storm Sewer	
FUTURE	
Sanitary Sewer	
Water	
Hyd. w\Valve	
Storm Sewer	

Call 48 Hours before digging:
811 or call811.com
Common Ground Alliance

STORM SEWER CASTING SCHEDULE			
STRUCTURE			CASTING TYPE
NUMBER	TYP.	DIA.	
329	CBMH	48"	R-3067-V
330	CB	2'x3'	R-3067-V
331	CBMH	48"	R-3067-V
332	CB	2'x3'	R-3067-V

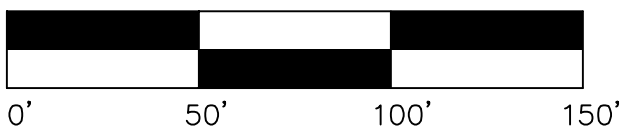

Latest Revision Date: 06/12/18

0014194.010AF01.dwg

Date: 05/02/18 Sheet: 3 OF 13

Westwood

Phone (952) 937-5150 12701 Whitewater Drive, Suite #300
Fax (952) 937-5822 Minnetonka, MN 55343
Toll Free (888) 937-5150 westwoodps.com
Westwood Professional Services, Inc.

I hereby certify that this plan was prepared by me or under my direct supervision and that I am a duly licensed PROFESSIONAL ENGINEER under the laws of the State of Minnesota.

Francis D Hagen II
Date: 06/12/18 License No. 17716

Revisions:

06/12/18	ADD TEMP CUL-DE-SAC & REMOVE PED RAMPS

Designed:	FDH II
Checked:	FDH II
Drawn:	DWR
Record Drawing by/date:	

Prepared for:

DR Horton Custom Homes
20860 Kenbridge Court, Suite 100
Lakeville, MN, 55044

Windermere Way

Shakopee, Minnesota

Overall Site Plan