


SHAKOPEE 2020 SCADA SYSTEM IMPROVEMENTS

SHAKOPEE, MINNESOTA

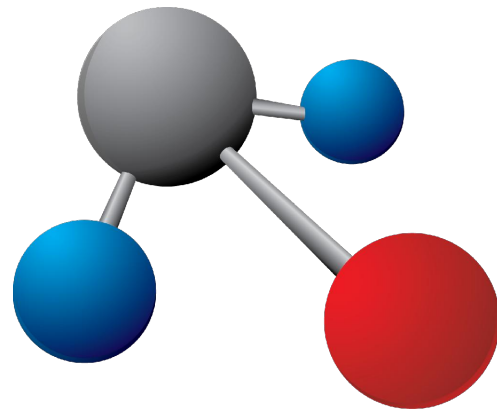

PREPARED FOR:
CITY OF SHAKOPEE



City Project No.: SAN19-005
AE2S Project No.: 05475-2020-007

MARCH
2021

PROJECT DRAWINGS

Advanced Engineering and Environmental Services, Inc.
Water Tower Pl Business Ctr
6901 E Fish Lake Rd Ste 184 Maple Grove, MN 55369
(t) 763-463-5036 (f) 763-463-5037 www.ae2s.com

INDEX OF DRAWINGS

SHEET	DESCRIPTION
G001	COVER SHEET
G002	LOCATION AND VACINITY MAP
E001	ELECTRICAL SYMBOLS AND ABBREVIATIONS
E002	SCADA NETWORK OVERVIEW
E003	OVERALL LOCATION SITE PLAN
E101	WD04 LOCATION SITE PLAN
E102	RD09 LOCATION SITE PLAN
E103	L16 LOCATION SITE PLAN
E104	L16 VARIOUS IMAGES
E105	L16 BACKPANEL DETAIL
E106	L16 CONTROL PANEL IO SCHEDULE
E107	ED02 LOCATION SITE PLAN
E108	ID82 LOCATION SITE PLAN
E109	ID129 LOCATION SITE PLAN
E110	ID131 LOCATION SITE PLAN
E111	ID132 LOCATION SITE PLAN
E112	PUBLIC WORKS MASTER PLC
E113	PUBLIC WORKS - SCADA MASTER PLC PANEL
E114	SCADA MASTER PLC CONTROL PANEL IO SCHEDULE
E501	FLOW MONITORING CONTROL PANEL LAYOUT
E502	FLOW MONITORING CONTROL PANEL IO SCHEDULE
E601	FLOW MONITORING CONTROL PANEL ONE-LINE DIAGRAM
E602	ID 129 CONTROL PANEL LAYOUT
E603	ID 129 CONTROL PANEL IO SCHEDULE
E604	ID129 CONTROL PANEL ONE-LINE DIAGRAM
E605	ID131 AND ID132 CONTROL PANEL LAYOUT
E606	ID131 AND ID132 CONTROL PANEL IO SCHEDULE
E607	TYPICAL WIRING SCHEMATICS
E608	VARIOUS DETAILS
E609	VARIOUS DETAILS

ENGINEERING TEAM

ELECTRICAL ENGINEER
Advanced Engineering and
Environmental Services, Inc.

CERTIFICATION


ELECTRICAL ENGINEER
Advanced Engineering and
Environmental Services, Inc.

I HEREBY CERTIFY THAT THIS PLAN, SPECIFICATION, OR REPORT WAS
PREPARED BY ME OR UNDER MY DIRECT SUPERVISION AND THAT I AM
A DULY LICENSED PROFESSIONAL ENGINEER UNDER THE LAWS OF
THE STATE OF MINNESOTA.


SIGNATURE: 

TYPED NAME: CHARLES HAUPERT
MARCH 03, 2021 REG. NO. 50464

Certification Of Individual
Project Design Disciplines Are
Included On Their Individual
Drawings, Respectively.

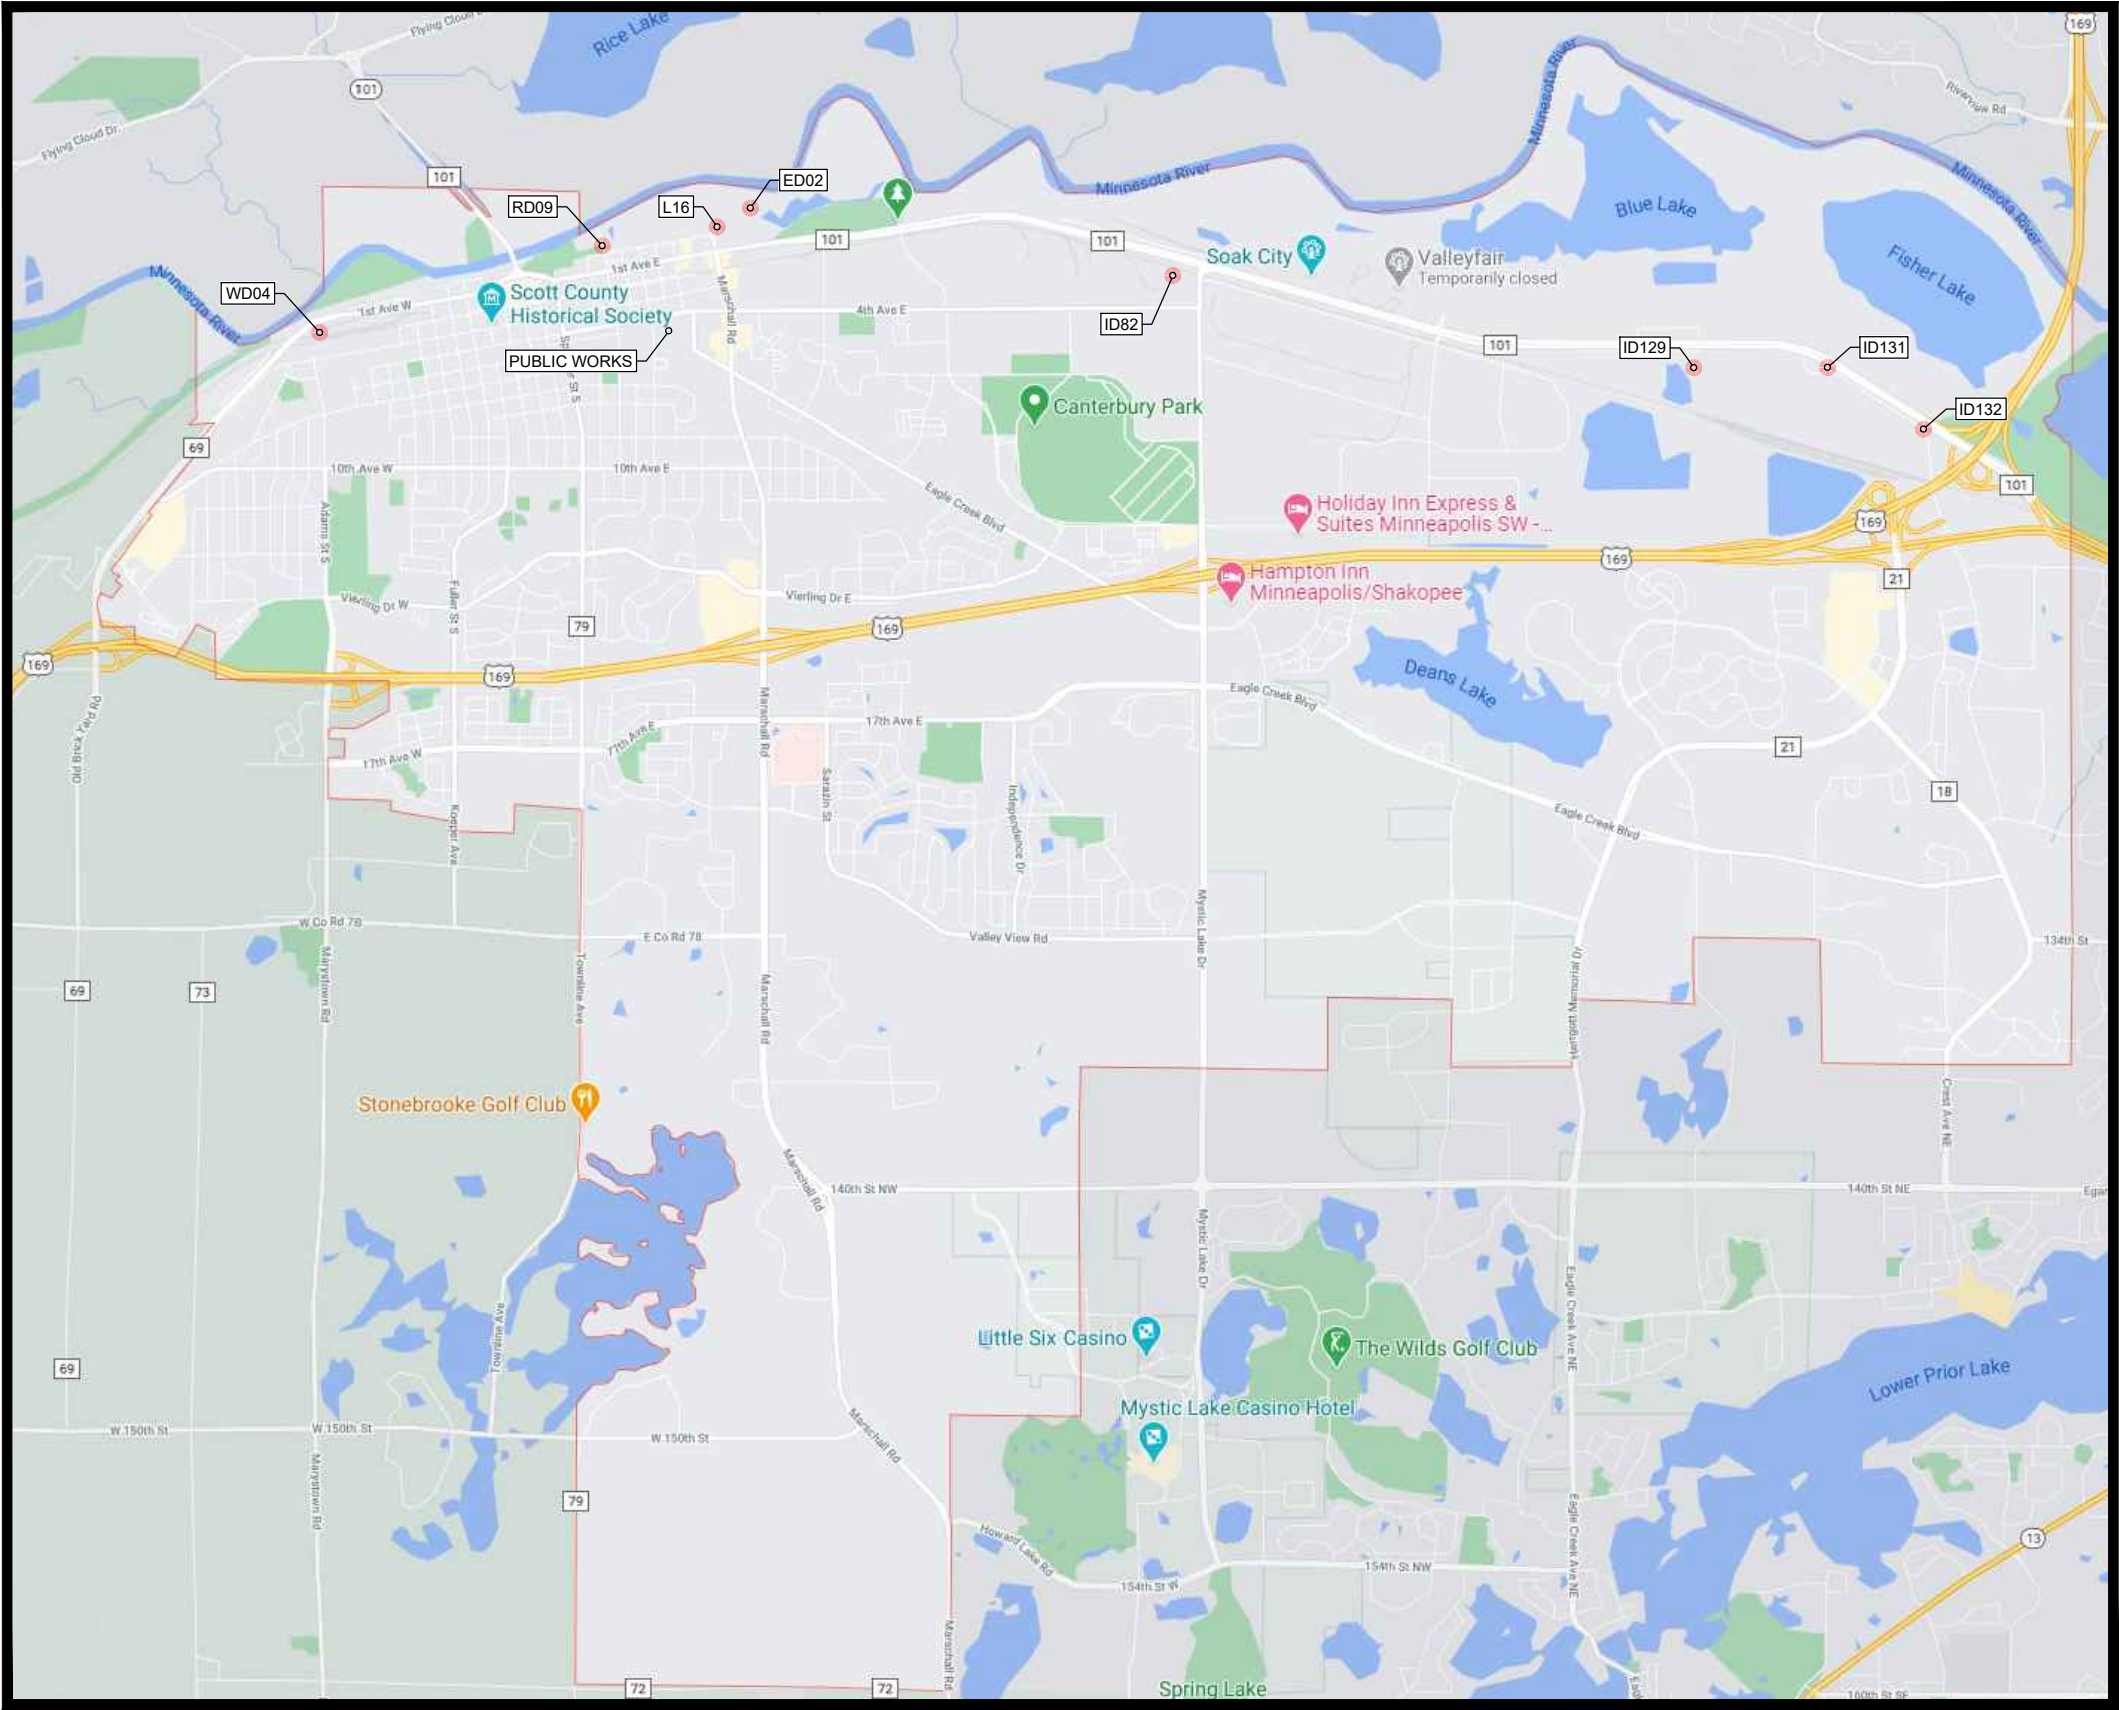

 CITY OF SHAKOPEE, MN
--FOR REFERENCE ONLY--



I HEREBY CERTIFY THAT THIS PLAN, SPECIFICATION, OR REPORT WAS PREPARED BY ME OR UNDER MY CLOSE PERSONAL SUPERVISION AND THAT I AM A DULY LICENSED PROFESSIONAL ENGINEER UNDER THE LAWS OF THE STATE OF MINNESOTA.

SIGNATURE: *Charles Haupert*

TYPED NAME: CHARLES HAUPELT
REG. NO. 50484

SHAKOPEE 2020 SCADA SYSTEM IMPROVEMENTS
CITY OF SHAKOPEE
SHAKOPEE, MINNESOTA
LOCATION AND VICINITY MAP

DRAWING TYPE
CONST

PREPARED BY
PGM

CHECKED / APPROVED
ASP / CDH



DATE
MARCH 2021

PROJECT NUMBER
05475-2020-007

DRAWING
G002

SYM	DATE	DESCRIPTION	APPR



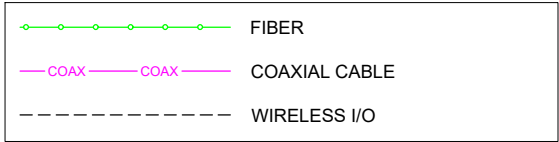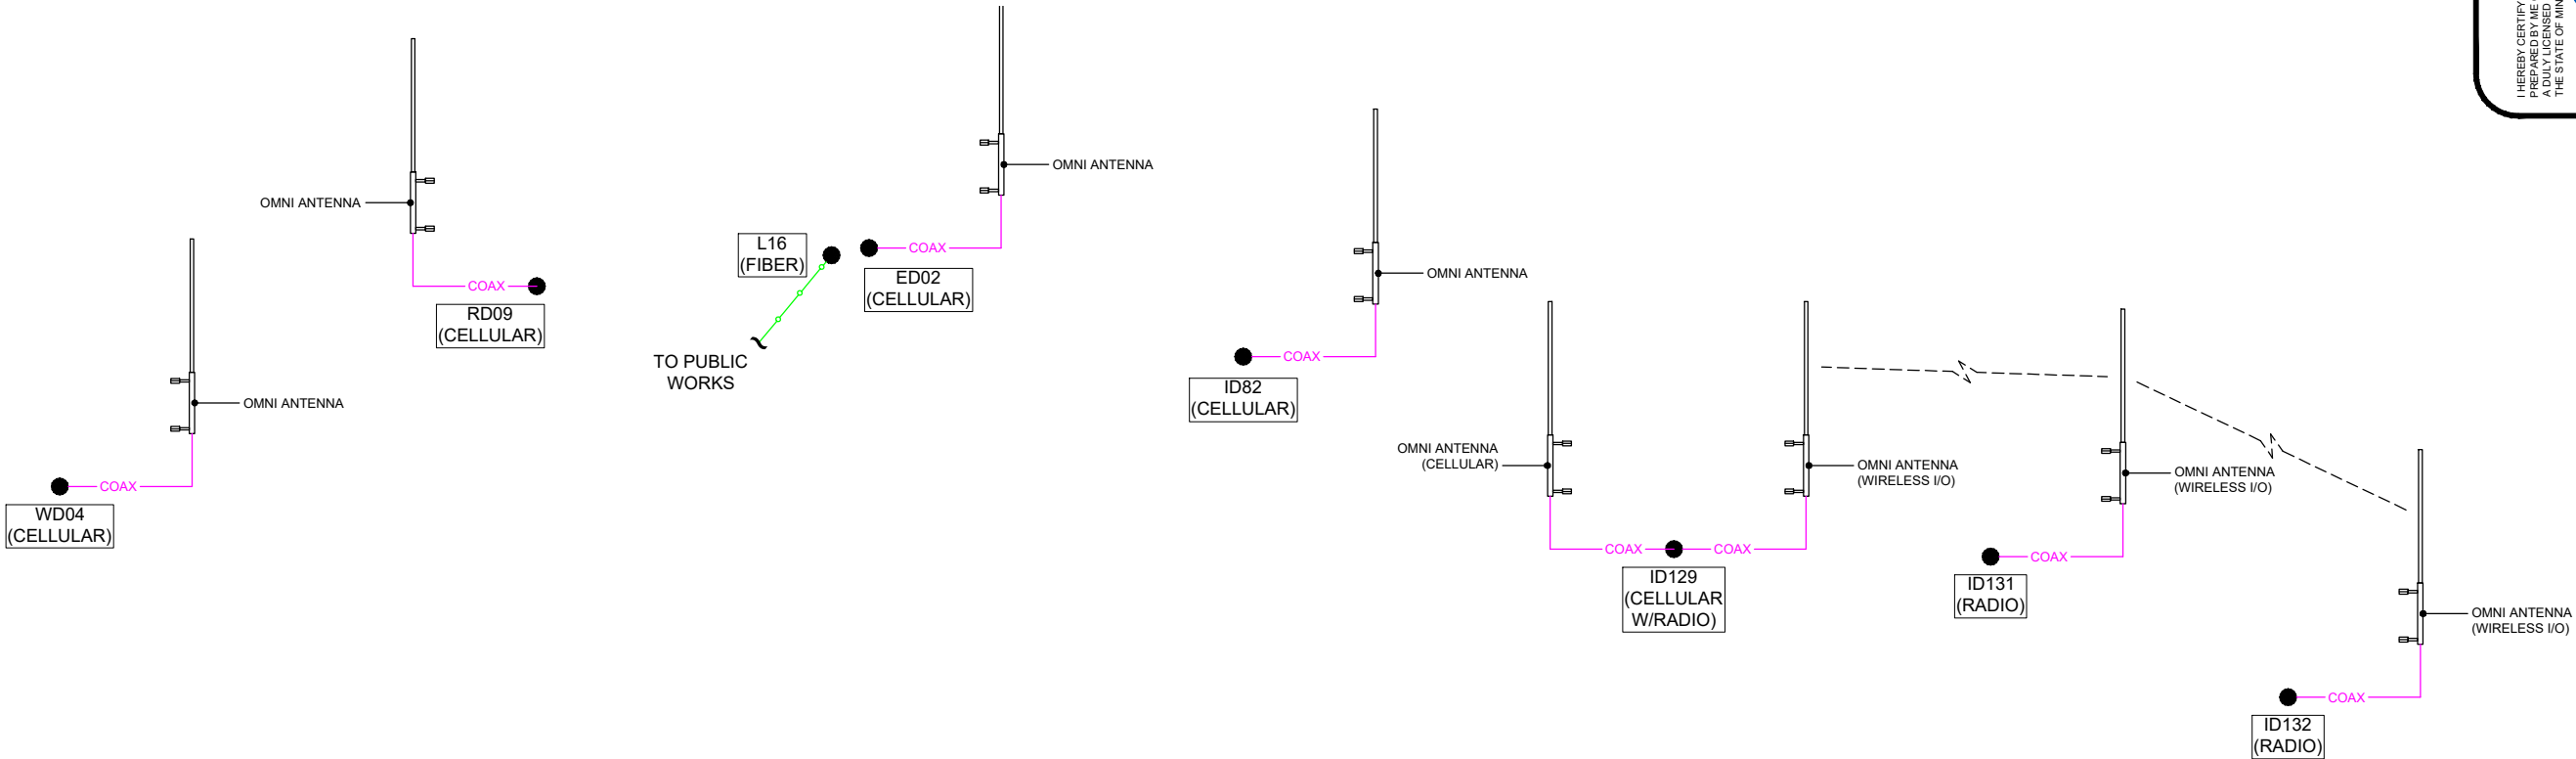

1 SCADA NETWORK OVERVIEW
E002 SCALE: N.T.S.

I HEREBY CERTIFY THAT THIS PLAN, SPECIFICATION, OR REPORT WAS PREPARED BY ME OR UNDER MY DIRECT SUPERVISION AND THAT I AM A DULY LICENSED PROFESSIONAL ENGINEER UNDER THE LAWS OF THE STATE OF MINNESOTA.

SIGNATURE: *Charles Haupert*
TYPED NAME: CHARLES HAUPELT
REG. NO.: 50484
MARCH 03, 2021


SHAKOPEE 2020 SCADA SYSTEM IMPROVEMENTS
CITY OF SHAKOPEE
SHAKOPEE, MINNESOTA
SCADA NETWORK OVERVIEW

DRAWING TYPE
CONST
PREPARED BY
PGM
CHECKED / APPROVED
ASP / CDH
DATE
MARCH 2021
PROJECT NUMBER
05475-2020-007

DRAWING
E002



SYM	DATE	DESCRIPTION	APPR

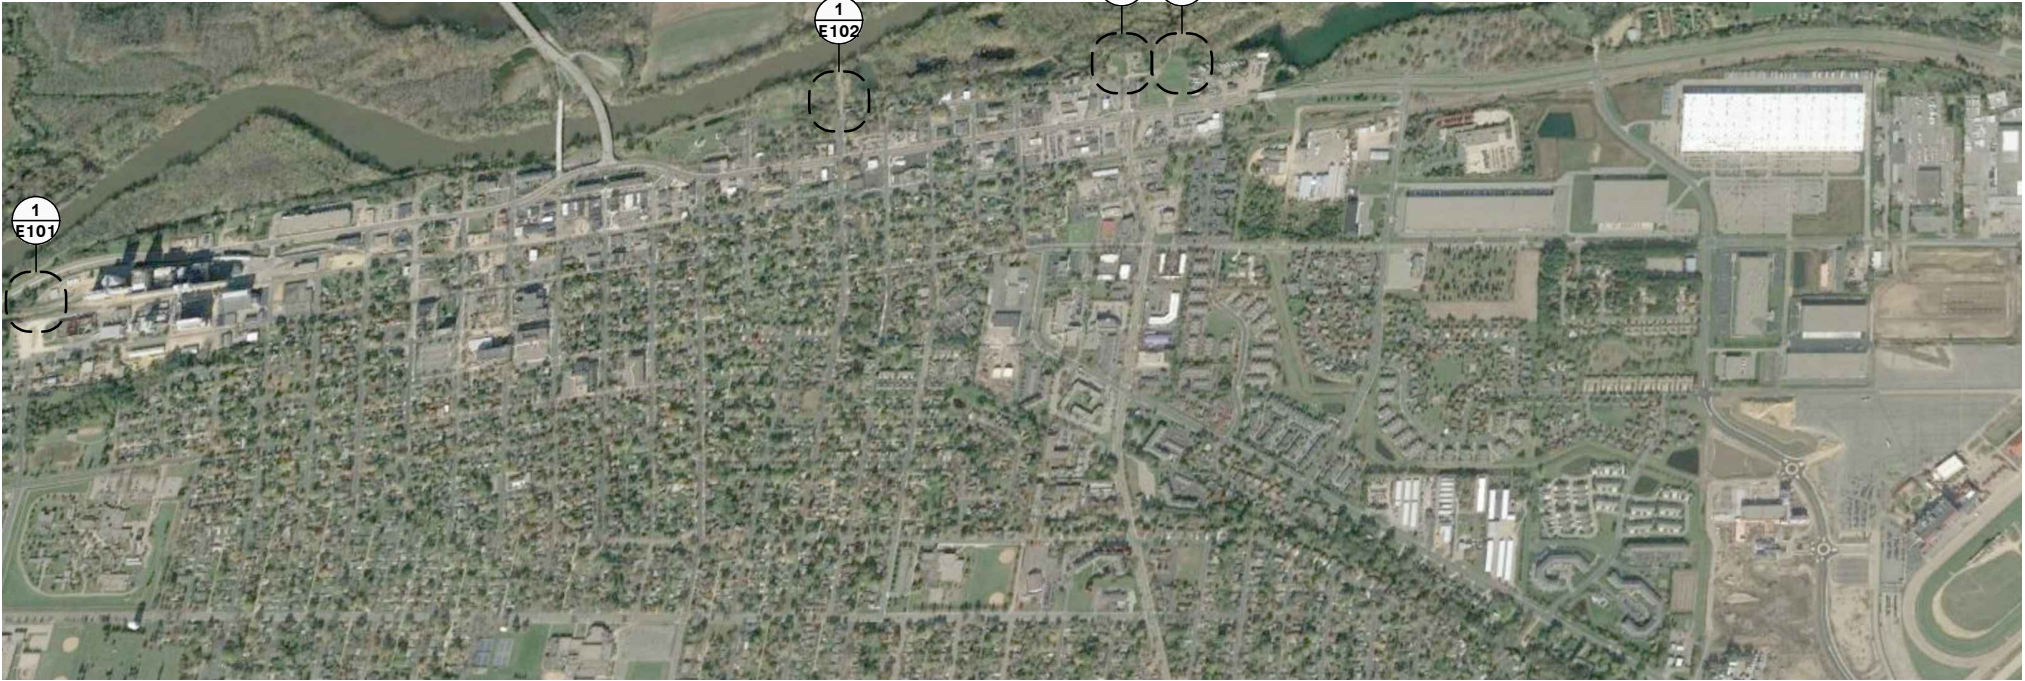

1 OVERALL LOCATION SITE PLAN
E003 SCALE: N.T.S.



GENERAL NOTES
1. SEE SHEET E001 FOR GENERAL NOTES.

I HEREBY CERTIFY THAT THIS PLAN, SPECIFICATION, OR REPORT WAS
PREPARED BY ME OR UNDER MY CLOSE PERSONAL SUPERVISION AND THAT I AM
A DULY LICENSED PROFESSIONAL ENGINEER UNDER THE LAWS OF
THE STATE OF MINNESOTA.

SIGNATURE: *Charles Hauptert*

TYPED NAME: CHARLES HAUPTERT
MARCH 03, 2021 REG. NO. 50484



SHAKOPEE 2020 SCADA SYSTEM IMPROVEMENTS
CITY OF SHAKOPEE
SHAKOPEE, MINNESOTA
OVERALL LOCATION SITE PLAN

DRAWING TYPE
CONST
PREPARED BY
PGM
CHECKED / APPROVED
ASP / CDH
DATE
MARCH 2021
PROJECT NUMBER
05475-2020-007


DRAWING
E003



1
E104 VFD 3 PUMP MODULE INSTALLATION IMAGE



2
E104 L16 CONTROL PANEL FRONT DOOR

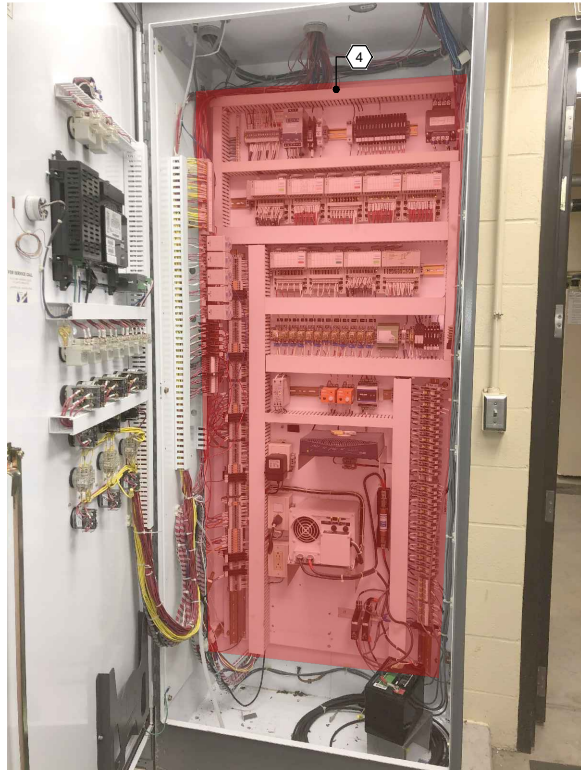

3
E104 L16 BACKPANEL REPLACEMENT IMAGE



4
E104 L16 OMNI MONITORING SYSTEM REMOVAL



5
E104 L16 MCC AND CONTROL PANEL LAYOUT

DEMOLITION LEGEND

- ITEMS TO BE REMOVED
- ITEMS TO BE REUSED

GENERAL NOTES

- SEE SHEET E001 FOR GENERAL NOTES.
- ALL EQUIPMENT REMOVED SHALL BE OFFERED TO CITY BEFORE DISPOSAL.

DEMOLITION NOTES

- REMOVE EXISTING OMNI MONITORING ENCLOSURES AND UNUSED CIRCUITRY, CONDUIT, AND MOUNTING EQUIPMENT TO SOURCE. PATCH ANY HOLES AFTER REMOVAL. EXISTING SIGNALS FOR "GRINDER RUNNING" AND "GRINDER ALARM" TO BE INTERCEPTED IN CONDUIT ABOVE L16 CONTROL PANEL AND ROUTED INTO L16 CONTROL PANEL WITH NEW SECTION CONDUIT, TERMINATING SIGNALS IN CONTROL PANEL. EXISTING GRINDER SIGNALS CONDUIT ROUTED IN CONDUIT ABOUT 3 FEET ABOVE L16 CONTROL PANEL AS IT GOES TO OMNI ENCLOSURES. ANTICIPATE ENOUGH WIRE TO PULL SIGNALS BACK INTO CONTROL PANEL FROM OMNI ENCLOSURE LOCATIONS.

CONSTRUCTION NOTES

- INSTALL OWNER PROVIDED SULZER CA441 MOISTURE MONITORING MODULE AND SULZER CA442 TEMPERATURE MONITORING MODULE AND WIRE MONITORING SIGNALS BACK TO OWNER PROVIDED (CONTRACTOR INSTALLED) SULZER PC441 PUMP CONTROLLER IN CONTROL PANEL. INTERCEPT EXISTING MONITORING CIRCUITS FROM PUMP AND WIRE TO NEW MONITORING MODULES. CONFIRM EXACT INSTALL LOCATION WITH OWNER IN FIELD.
- INSTALL OWNER PROVIDED SULZER CA511 GRAPHICAL OPERATOR INTERFACE AND WIRE TO OWNER PROVIDED SULZER PC441 PUMP CONTROLLER IN CONTROL PANEL.
- REMOVE AND REPLACE OIT (SECTION 409513). PROVIDE IN-LINE FUSE ON POSITIVE CIRCUIT. REMOVE DIGITAL DISPLAY. PROVIDE COLOR-MATCHING BEZEL FOR OIT AND SULZER CA511 INSTALLATION.
- REMOVE EXISTING BACK PANEL (INCLUSIVE OF PLC, I/O MODULES, BATTERY-BASED BACKUP POWER SYSTEM, RELAYS, TERMINALS) AND EXISTING SIDE BACK PANEL (INCLUSIVE OF TERMINALS, RELAYS). DISCONNECT FIELD WIRES IN PANEL. REPLACE WITH NEW COMPLETE BACKPANEL INCLUDING PLC, I/O MODULES AND OTHER EQUIPMENT AS NOTED ON E105. CONTRACTOR RESPONSIBLE FOR RE-TERMINATING I/O AND OTHER MISCELLANEOUS CIRCUITRY.

I HEREBY CERTIFY THAT THIS PLAN, SPECIFICATION, OR REPORT WAS PREPARED BY ME OR UNDER MY CLOSE PERSONAL SUPERVISION AND THAT I AM A DULY LICENSED PROFESSIONAL ENGINEER UNDER THE LAWS OF THE STATE OF MINNESOTA.

SIGNATURE: *Charles Hauwert*

TYPED NAME: CHARLES HAUWERT
REG. NO. 50484

SYM	DATE	DESCRIPTION	APPR



SHAKOPEE 2020 SCADA SYSTEM IMPROVEMENTS
CITY OF SHAKOPEE
SHAKOPEE, MINNESOTA
L16 VARIOUS IMAGES

DRAWING TYPE
CONST
PREPARED BY
PGM
CHECKED / APPROVED
ASP / CDH
DATE
MARCH 2021
PROJECT NUMBER
05475-2020-007

DRAWING
E104