


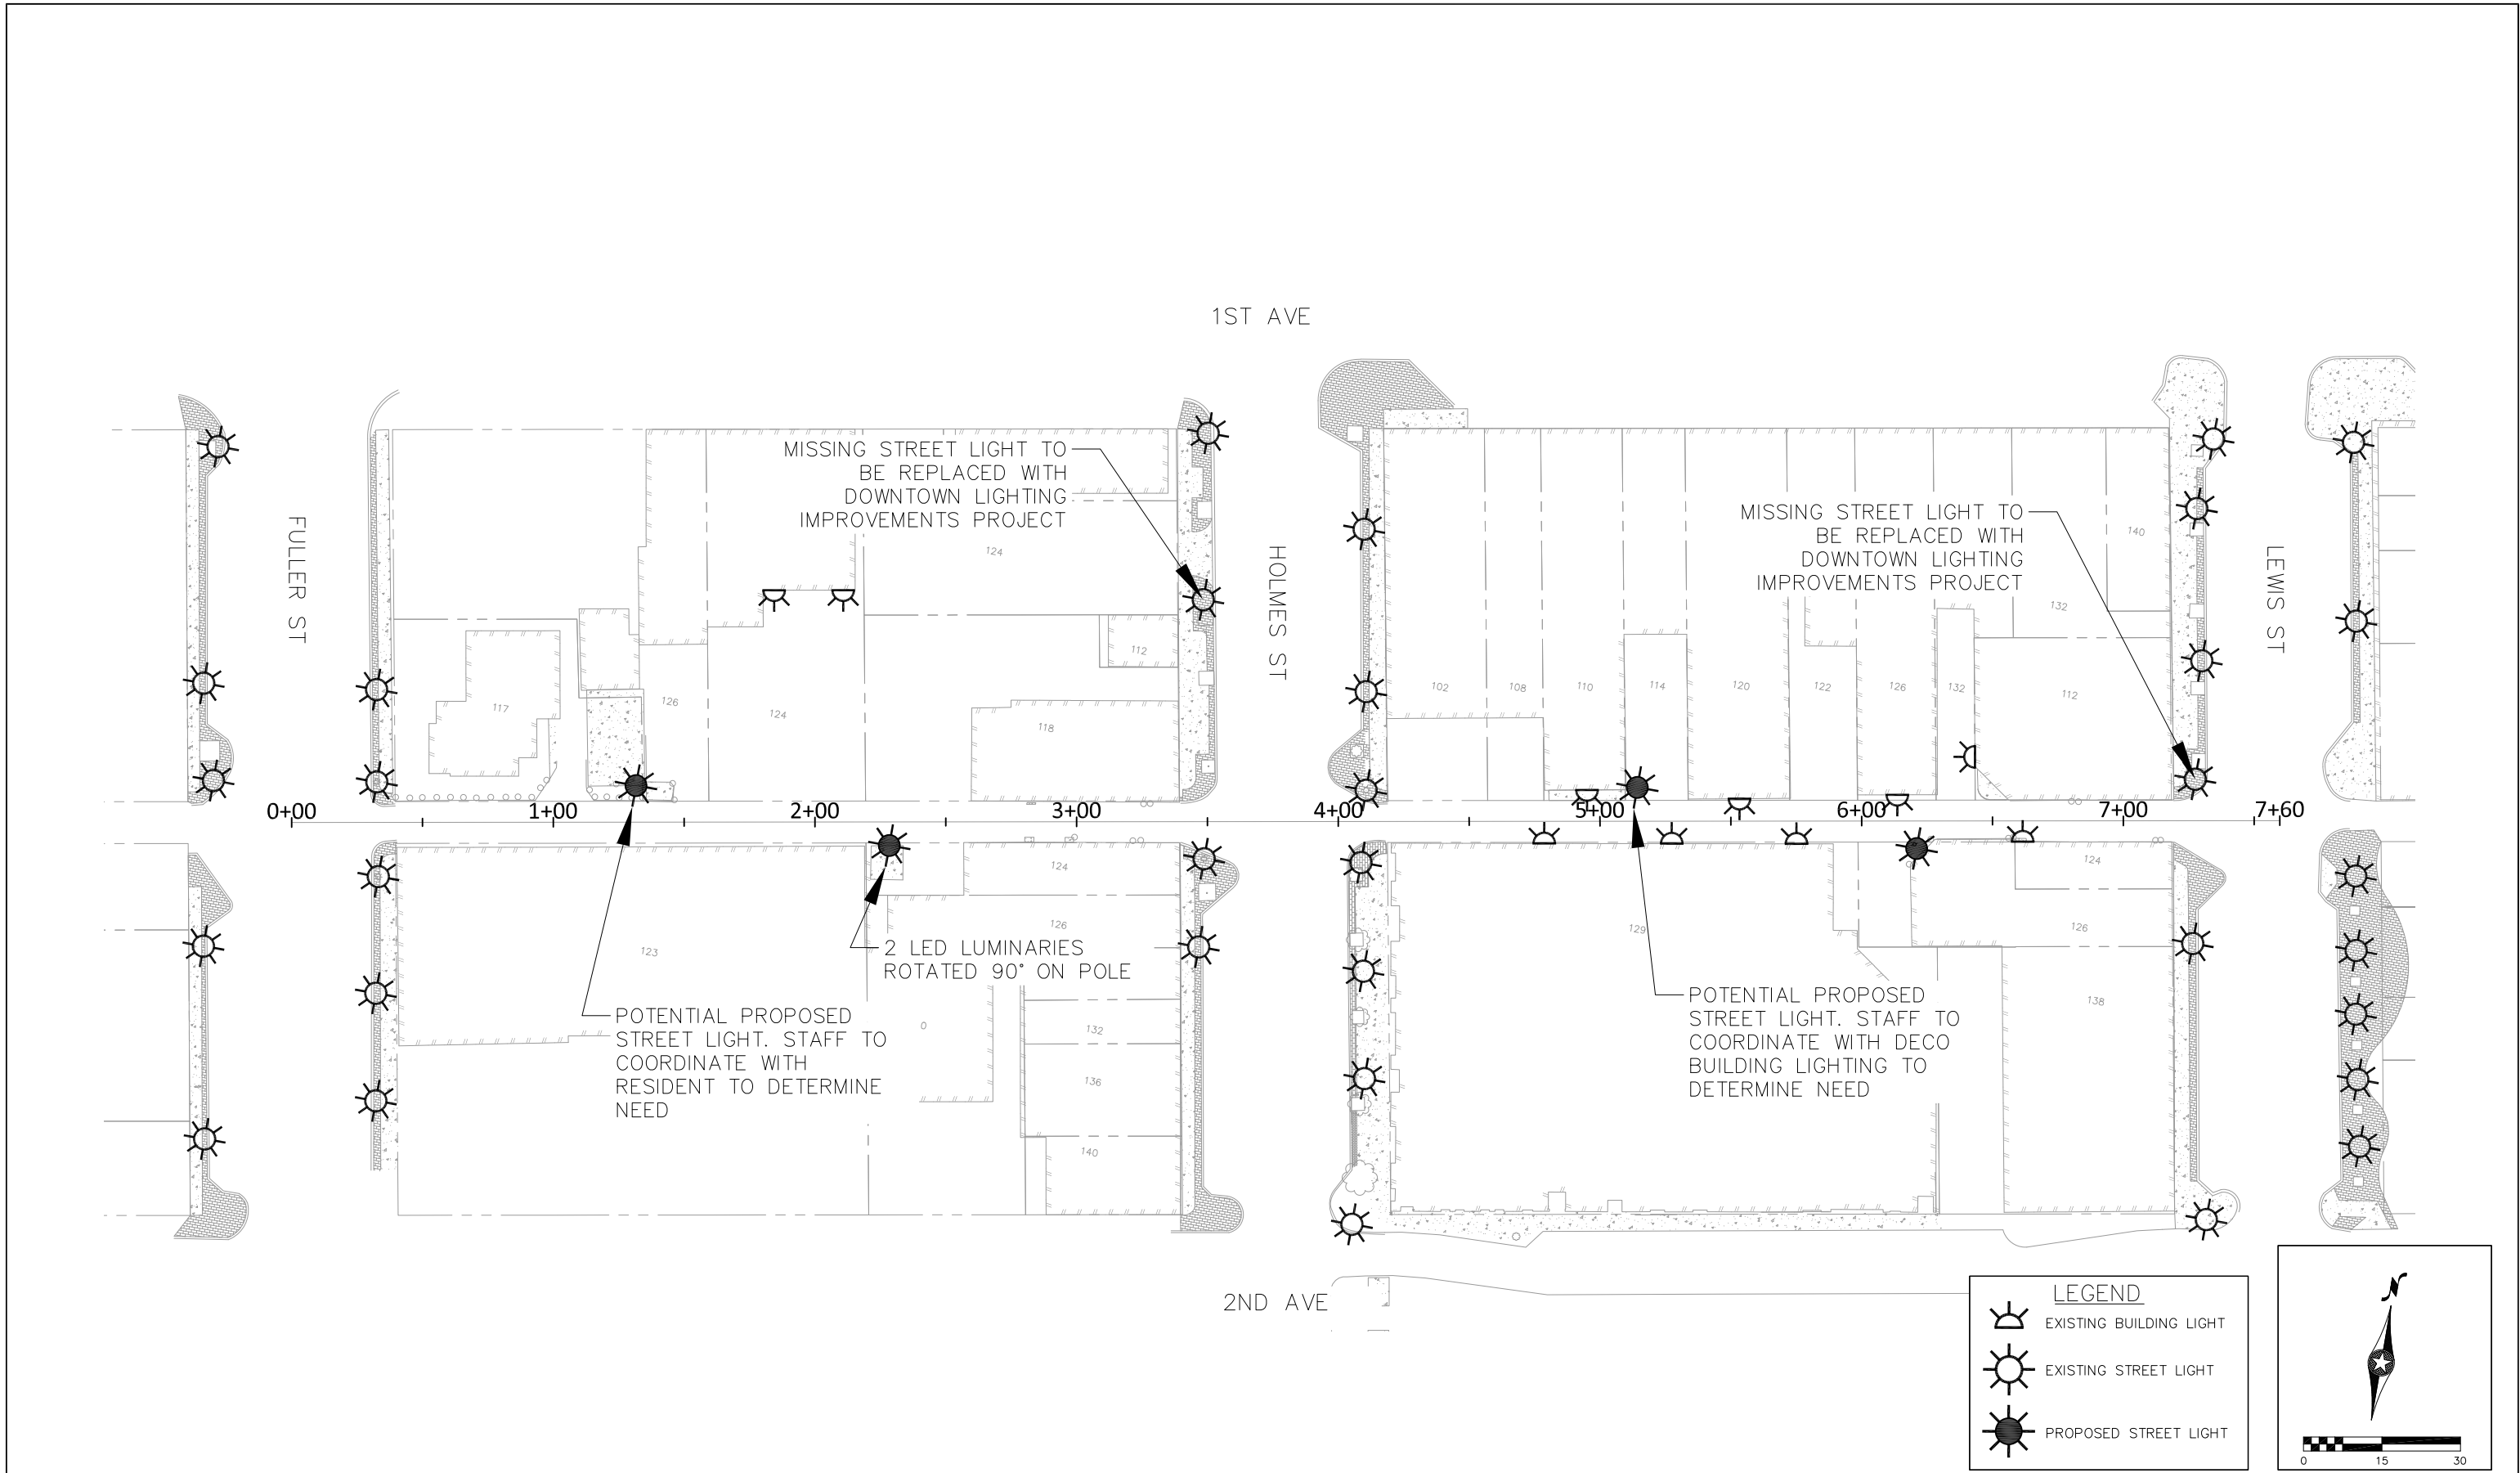

NO.	DATE	BY	REVISION



I HEREBY CERTIFY THAT THIS PLAN, SPECIFICATION, OR REPORT WAS PREPARED BY ME OR UNDER MY DIRECT SUPERVISION AND THAT I AM A DULY LICENSED PROFESSIONAL ENGINEER UNDER THE LAWS OF THE STATE OF MINNESOTA.

SIGNATURE: _____ DATE: _____

PRINTED NAME: MICAH HECKMAN LIC. NO. 49589

DESIGNED BY: MH

DRAWN BY: AB

CHECKED BY: MH

DATE: XX/XX/XXXX

CITY PROJECT NO.
CIF-20-009

2021 ALLEY RECONSTRUCTION

LIGHTING PLANS